

DRAWING NUMBER
93132F1




LEGEND:

- POND/STREAMS
- ++++ RAILROAD
- 980 — SURFACE CONTOURS (FEET ABOVE MEAN SEA LEVEL)

NOTES:

1. TOPOGRAPHIC CONTOURS AND PROPERTY FEATURES WERE PROVIDED BY OTHERS AND HAVE NOT BEEN VERIFIED BY CUMMINGS/RIEGER.

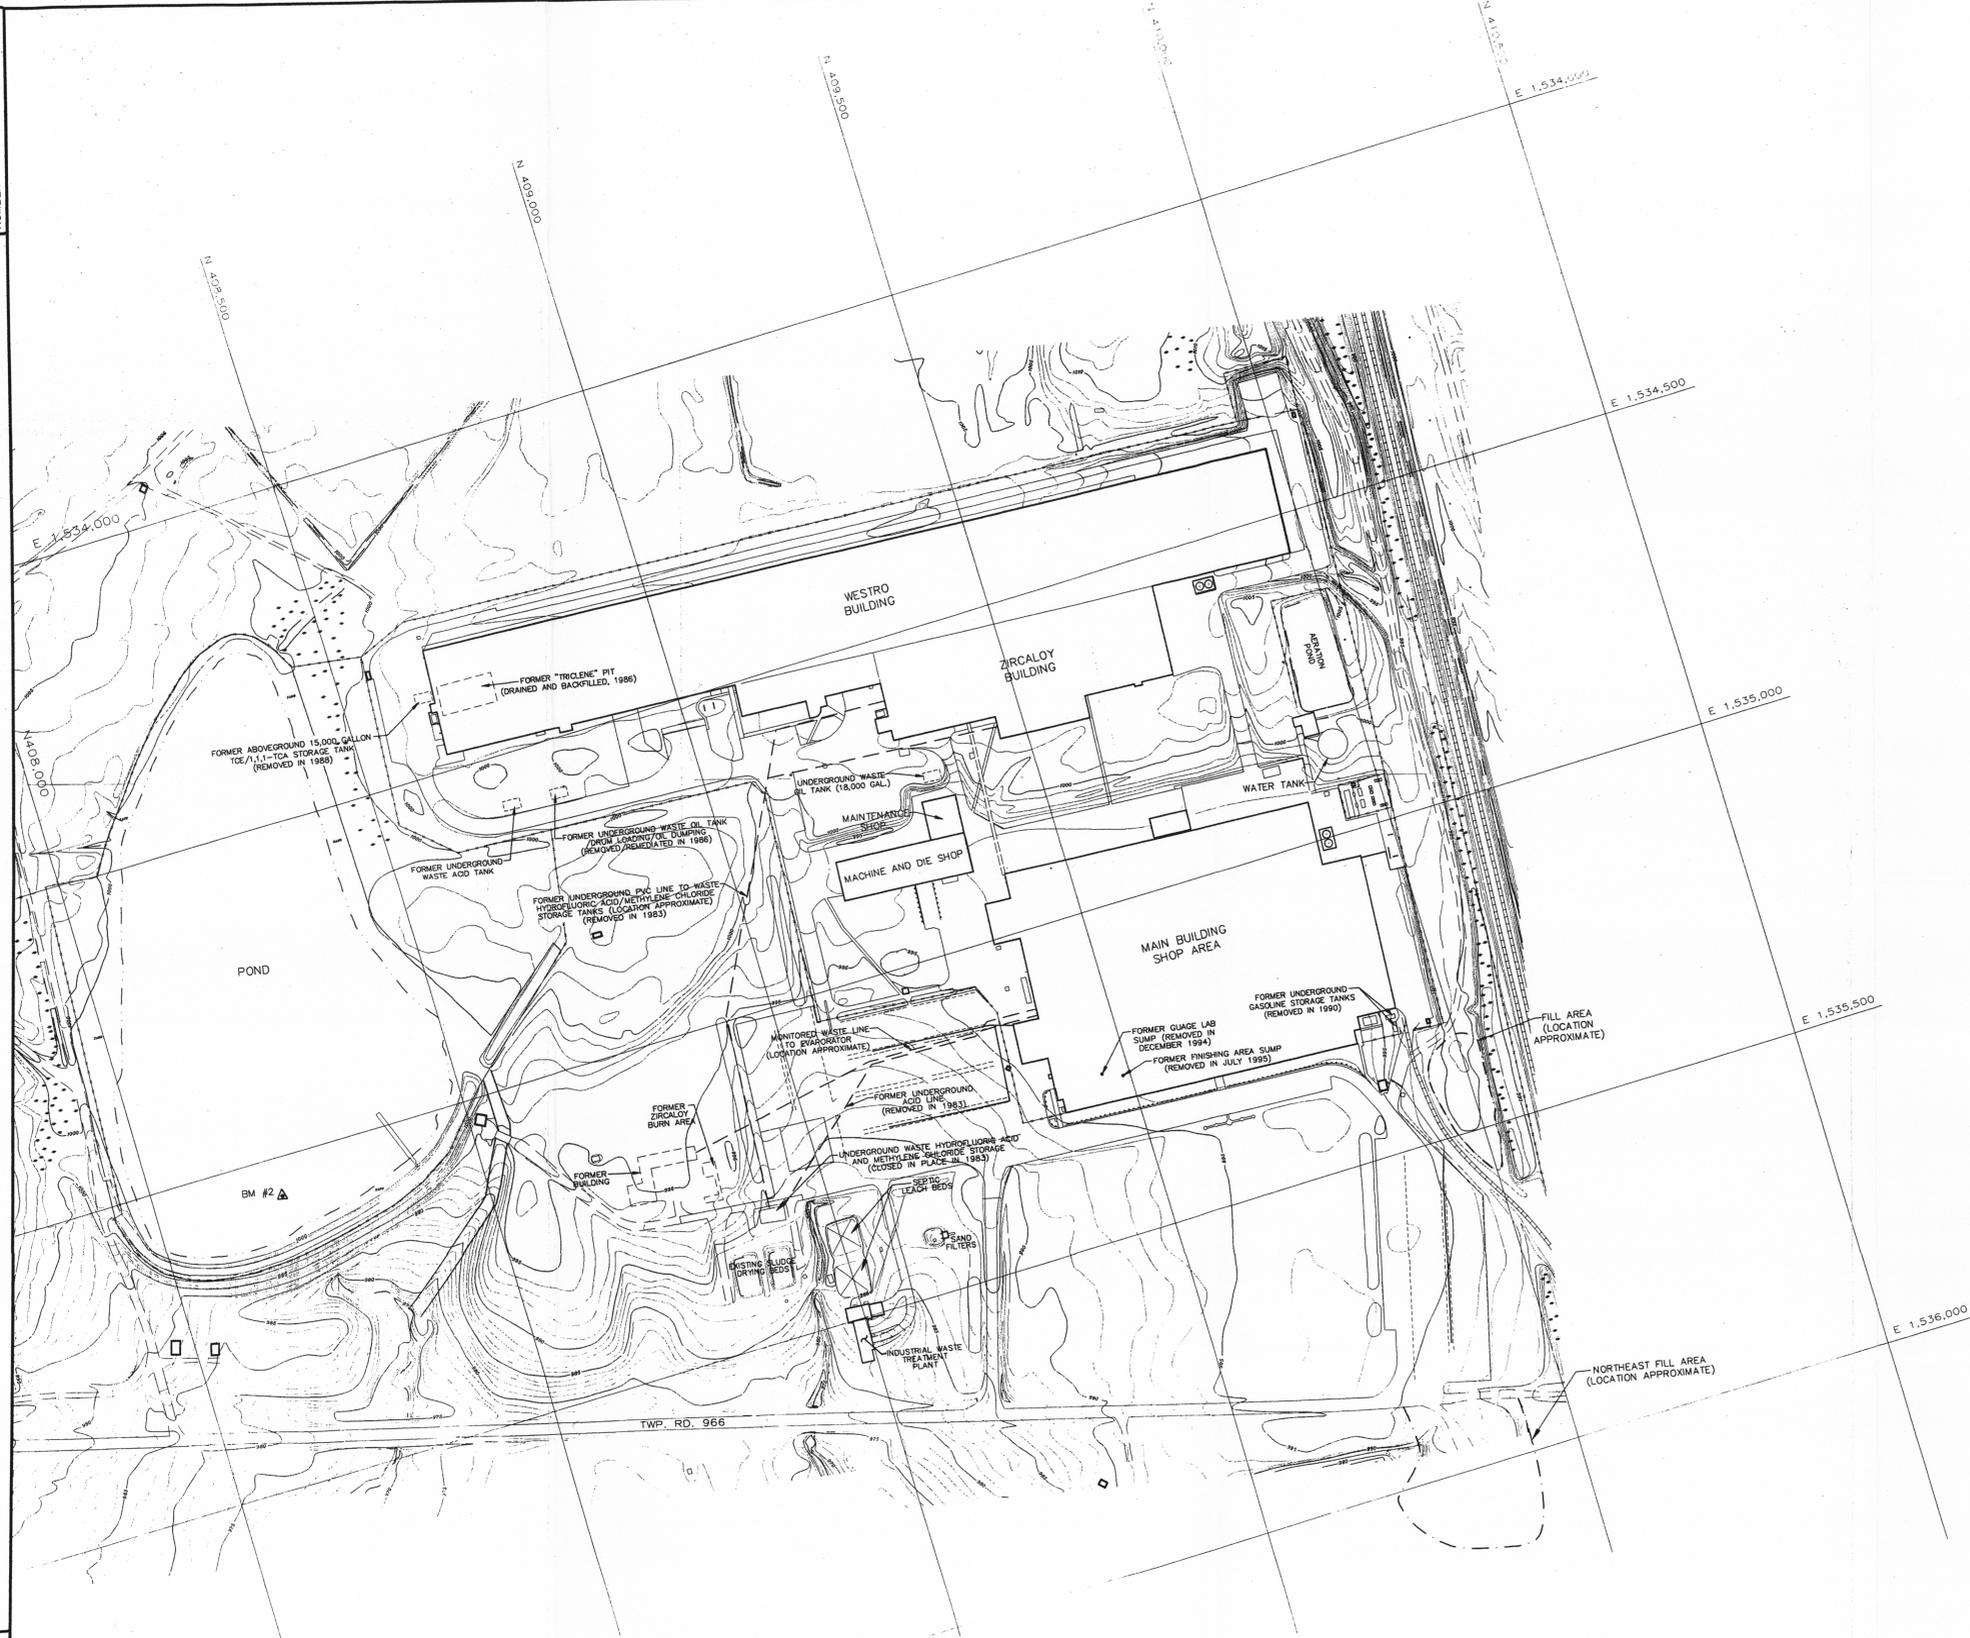

1' CONTOUR INTERVAL
APPROXIMATE SCALE
0 100 200 FEET

REVISIONS			
REV.	DESCRIPTION	DATE	APPROVED

CUMMINGS RIEGER CONSULTANTS, INC. CORPORATE HEADQUARTERS 350 Haymaker Road Parkway Building, Suite 201 Monroeville, PA 15146 (412) 373-5240 Fax: (412) 373-5242	FIGURE 18 SITE PLAN	
	SPECIALTY METALS PLANT BLAIRSVILLE, PENNSYLVANIA	
EASTERN REGIONAL HEADQUARTERS 258 Chapman Road Suite 202 Newark, DE 19702 (302) 731-9895 Fax: (302) 731-9809	PREPARED FOR WESTINGHOUSE ELECTRIC CORPORATION PITTSBURGH, PENNSYLVANIA	
SIZE: F DRAWN BY: B. MAURER CHECKED BY: D. CUSICK APPROVED BY: W. BAUGHMAN	DRAWING NUMBER: 93132F8 DATE: 11-17-95 DATE: 11-17-95 DATE: 11-17-95	SCALE: 1"=100' REV.

REFERENCE:
WESTINGHOUSE ELECTRIC CORPORATION, SPECIALTY METALS DIVISION,
BLAIRSVILLE, PENNSYLVANIA; FIGURE 6; TITLED: "SURFACE AND
GROUND WATER QUALITY MONITORING LOCATIONS NEAR PLANT
FACILITIES," PROJECT P6043.

PLOT SCALE: 1"=1'

D-6