


THOSE PORTIONS OF THIS DRAWING WHICH ARE COLORED CYAN INDICATE THAT THE COLORED ITEM IS SUBJECT TO AGING MANAGEMENT REVIEW

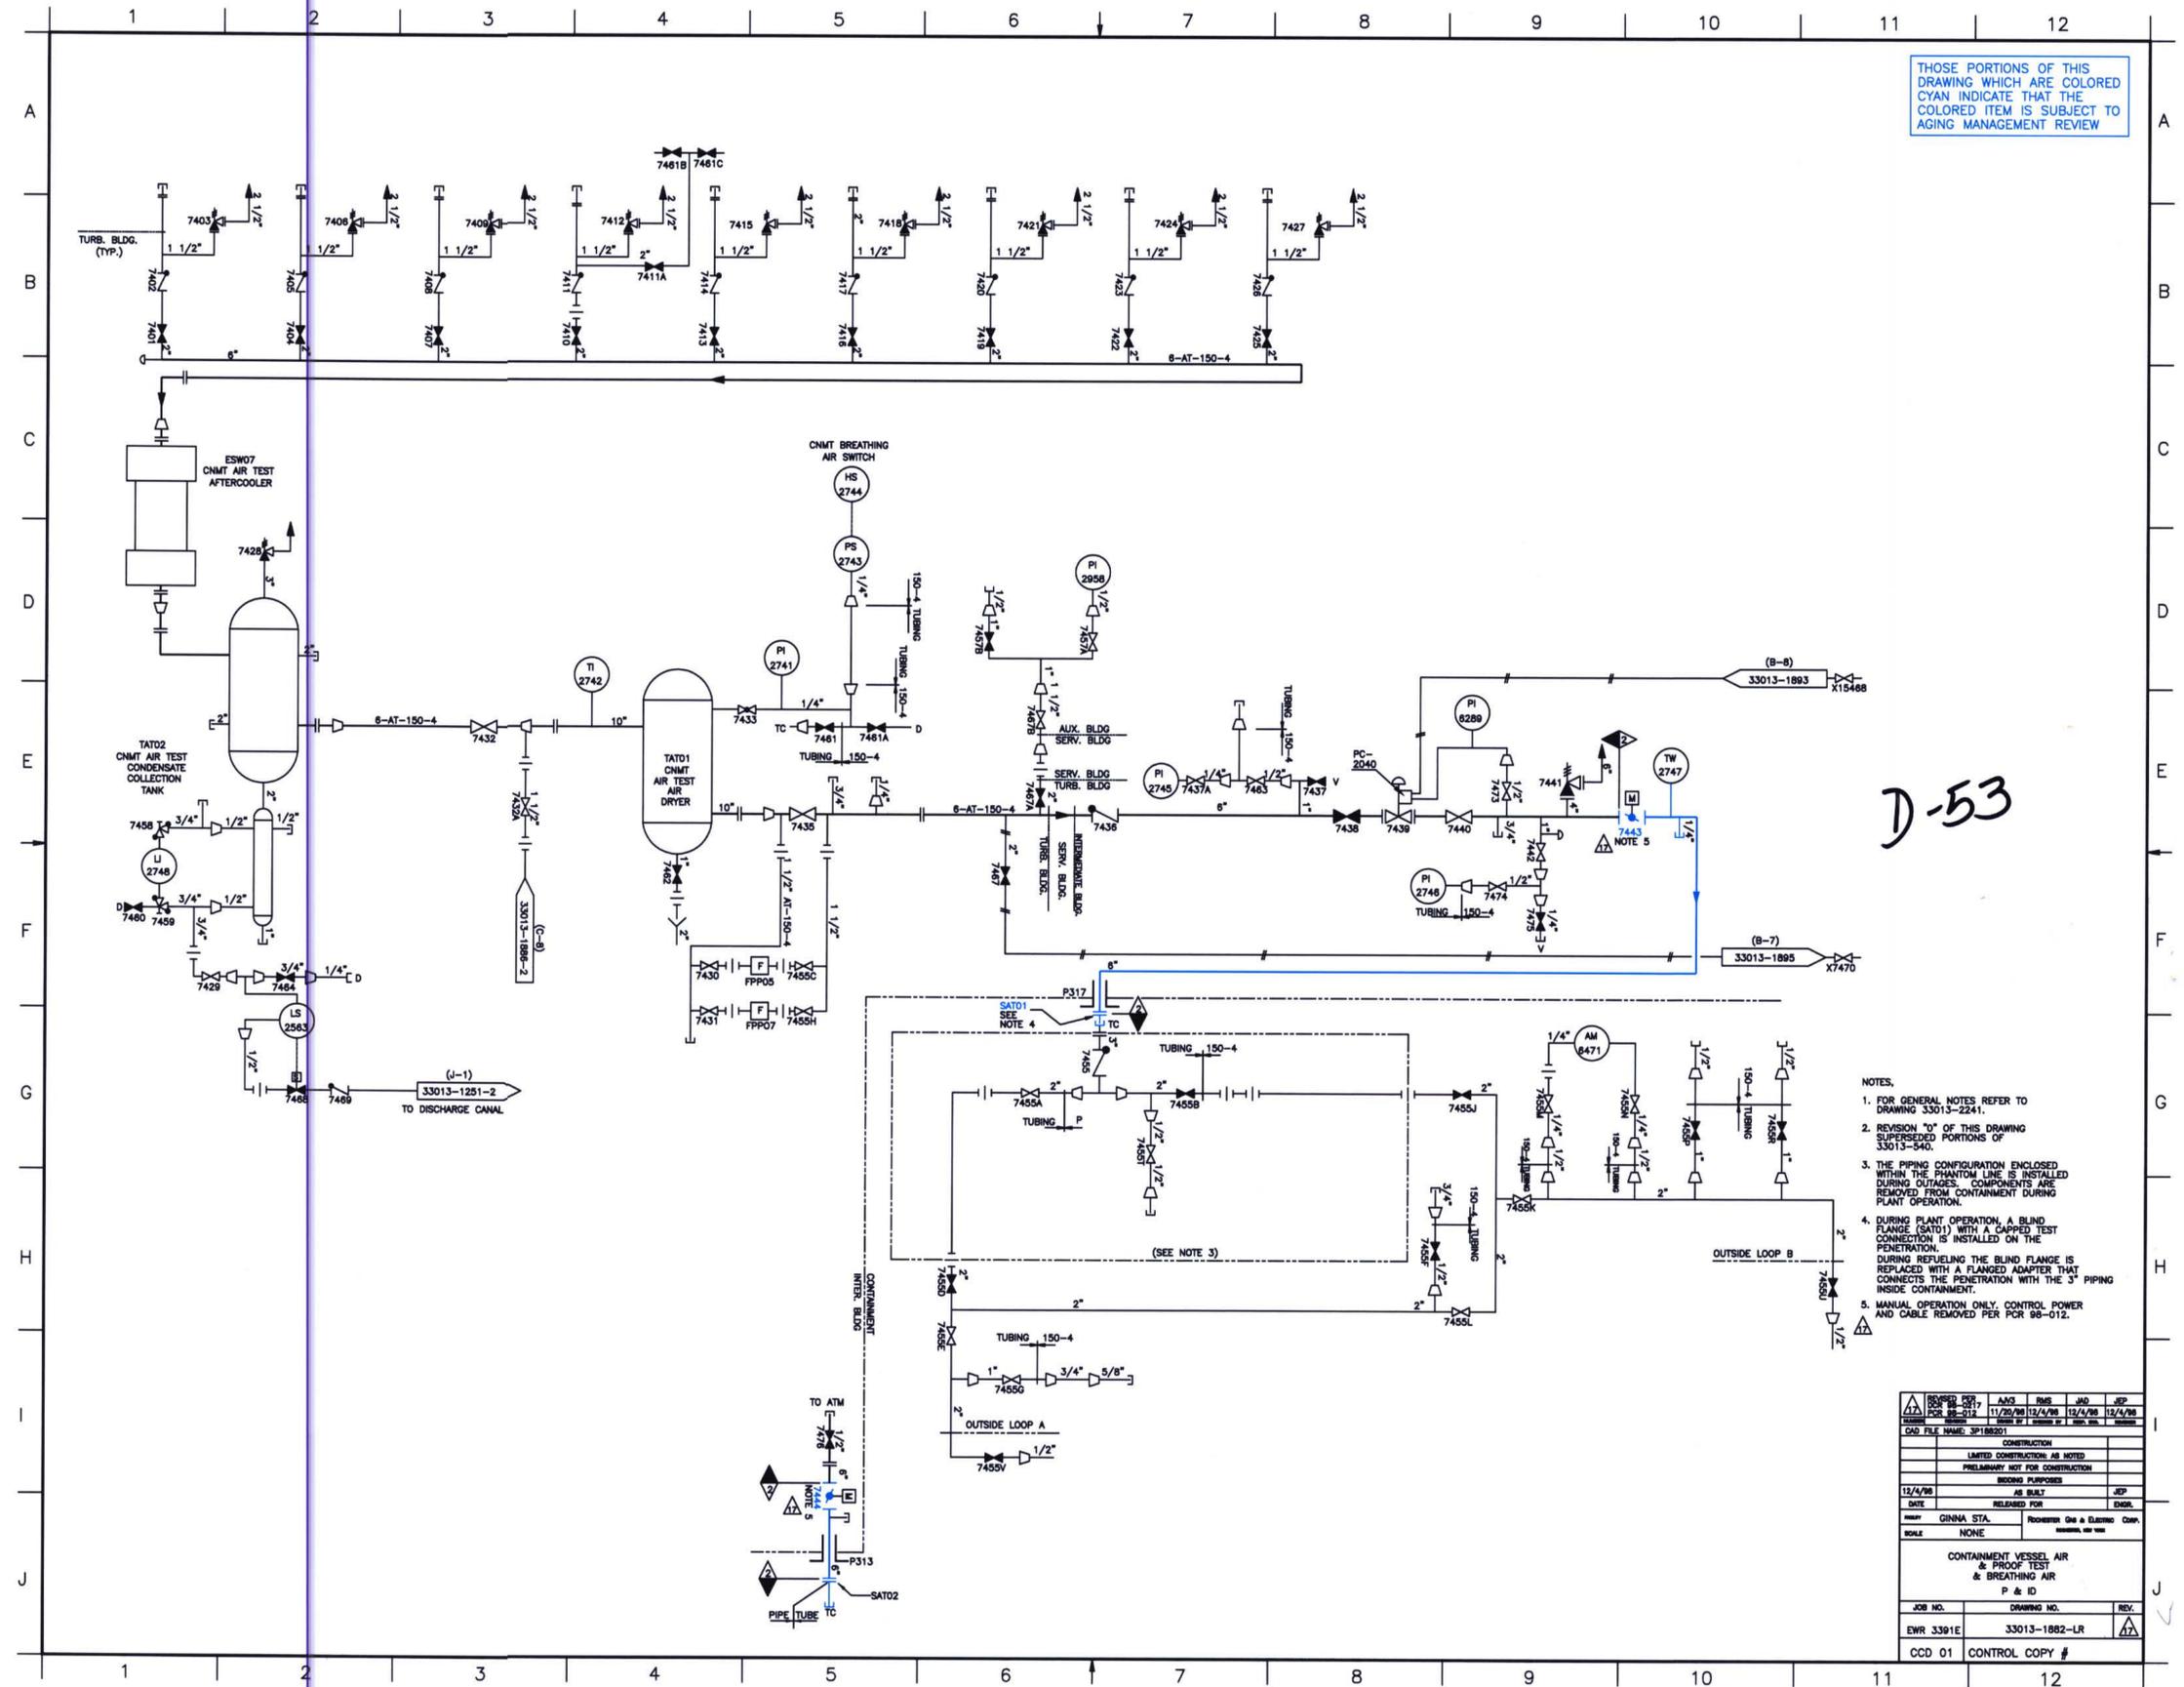

D-53

- NOTES:
1. FOR GENERAL NOTES REFER TO DRAWING 33013-2241.
 2. REVISION "0" OF THIS DRAWING SUPPRESSED PORTIONS OF 33013-540.
 3. THE PIPING CONFIGURATION ENCLOSED WITHIN THE PHANTOM LINE IS INSTALLED DURING OUTAGES. COMPONENTS ARE REMOVED FROM CONTAINMENT DURING PLANT OPERATION.
 4. DURING PLANT OPERATION, A BLIND FLANGE (SAT1) WITH A CAPPED TEST CONNECTION IS INSTALLED ON THE PENETRATION. DURING REFUELING THE BLIND FLANGE IS REPLACED WITH A FLANGED ADAPTER THAT CONNECTS THE PENETRATION WITH THE 3" PIPING INSIDE CONTAINMENT.
 5. MANUAL OPERATION ONLY. CONTROL POWER AND CABLE REMOVED PER PCR 98-012.

REVISED FOR	AMG	RMS	JND	JEP
PCR 98-012	11/20/98	12/4/98	12/4/98	12/4/98
CHD FILE NAME:	3P18801			
CONSTRUCTION				
LIMITED CONSTRUCTION AS NOTED				
PRELIMINARY NOT FOR CONSTRUCTION				
RECORD PURPOSE				
12/4/98	AS BUILT			JEP
DATE	RELEASED FOR			ENGR.
BY	GINMA STA.	Recorder: GIN & Electric Comp.		
SCALE	NONE			
CONTAINMENT VESSEL AIR & PROOF TEST & BREATHING AIR P & ID				
JOB NO.	DRAWING NO.			REV.
EWR 3391E	33013-1882-LR			1
CCD 01	CONTROL COPY #			