



LINES

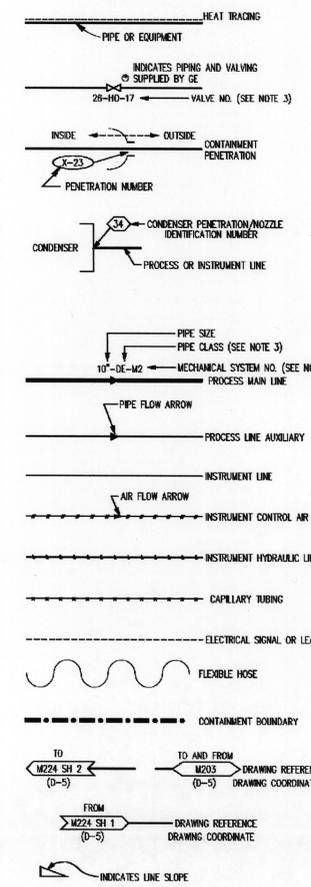

MISCELLANEOUS PIPE BOUNDARIES

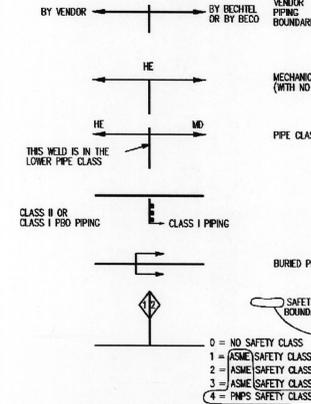


LOCAL VENT, DRAIN & TEST CONN **


	VENT	DRAIN	TEST CONN
VALVE ONLY			
VALVE W/WHIPPLE			
VALVE W/WHIPPLE/CAP			
	VALVE GLAND LEAK-OFF**	VALVE BODY DRAIN**	
VALVES (MANUAL)			
VALVE(S) WITH OPERATOR			

** NOTES:
1. CORRECT VALVE SYMBOL USED AS SPECIFIED.
2. CONNECTIONS ARE SAME PIPE CLASS AS MAIN LINE EXCEPT WHERE NOTED.


SYMBOLS

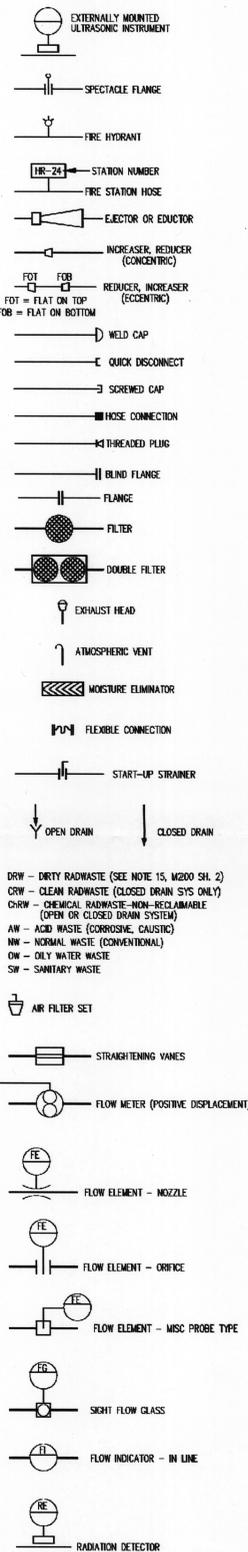

VALVES

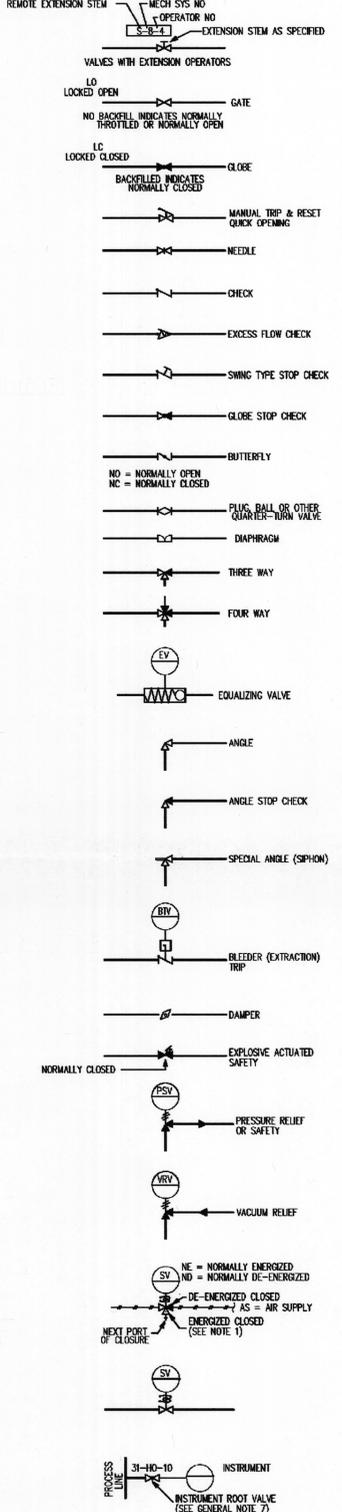


MECHANICAL AUXILIARIES

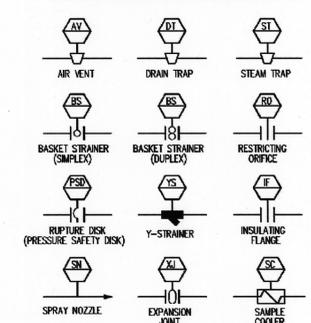


SAMPLING CONNECTIONS




CONTROL VALVES

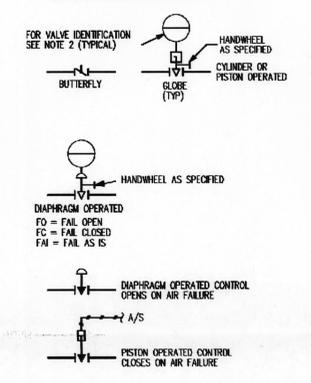


CONTROL VALVES-SELF CONTAINED

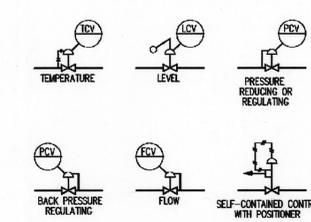

ACTUATORS

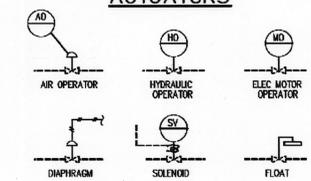

INSTRUMENTATION SYMBOLS

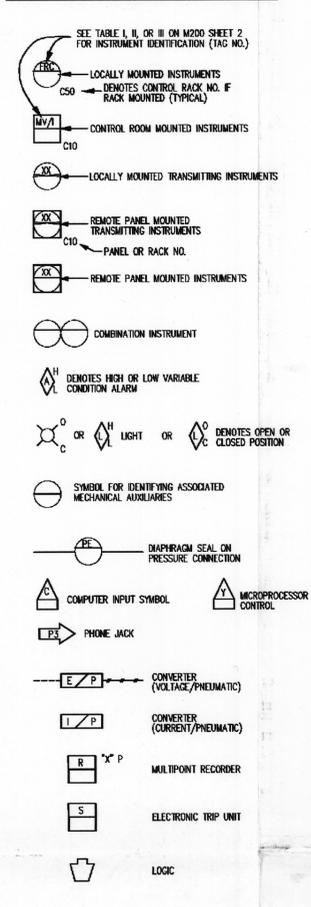

FOR NOTES & TABLES SEE SHEET 2

NO.	DATE	DESCRIPTION	BY	ENG	CHK	APP
E24	03/09	REVISED FOR PR 99-2096 PER DCN 0/237	CTS	AJB	DLJ	
E23	02/04	REVISED FOR PR 98-9537 PER DCN 0885	TEH	AJB	DLJ	
E20	04/04	ELECTRONIC CONVERSION PER DCN 97-00006	CTS	AJB	DLJ	
E21	04/04	REVISED PER DCN-94-90757	TEB	PDH	AJB	PCG
E20	04/04	REV PER DCN 84250P	TEB	PDH	AJB	PCG
E19	04/04	REVISED PER DCN 82900	TEB	PDH	AJB	PCG
E18	04/04	REVISED PER DCN 91-82718	TEB	PDH	AJB	PCG
E17	04/04	PER PHOENIX CHANGE RECORD	TEB	PDH	AJB	PCG

SCALE: 1/8" = 1'-0" DESIGNED BY: [Signature] DRAWN BY: [Signature]

Energy Nuclear Generation Company
PLYMOUTH STATION
PLYMOUTH, MA

TITLE: P & ID LEGEND

DRAWING NO.: M200 SH 1 E24

REV: [Blank]

41100-1903 FSAR FIGURE 1.3-2 SH 1 (REV 15)

NO.	DATE	DESCRIPTION	BY	ENG	CHK	APP
0	3-4-05					

REVISIONS

LRM-200-SH-01-0

CD FILE: LRA-M-200-SH-01-E24.DGN

CD FILE: M200SH1-CALS_E24.CAL

D-01