


NOTES:

1. ALL OF THE EQUIPMENT ON THIS P & ID HAS BEEN ABANDONED IN PLACE. REFER TO P & ID M218 SHEET 3 FOR ADDITIONAL INFORMATION. NONE OF THE EQUIPMENT ON THIS P & ID IS Q OR FPO.
2. TUBING PROCURED BY BECHTEL IN ACCORDANCE WITH FAIRBANKS-MORSE RECOMMENDATIONS.

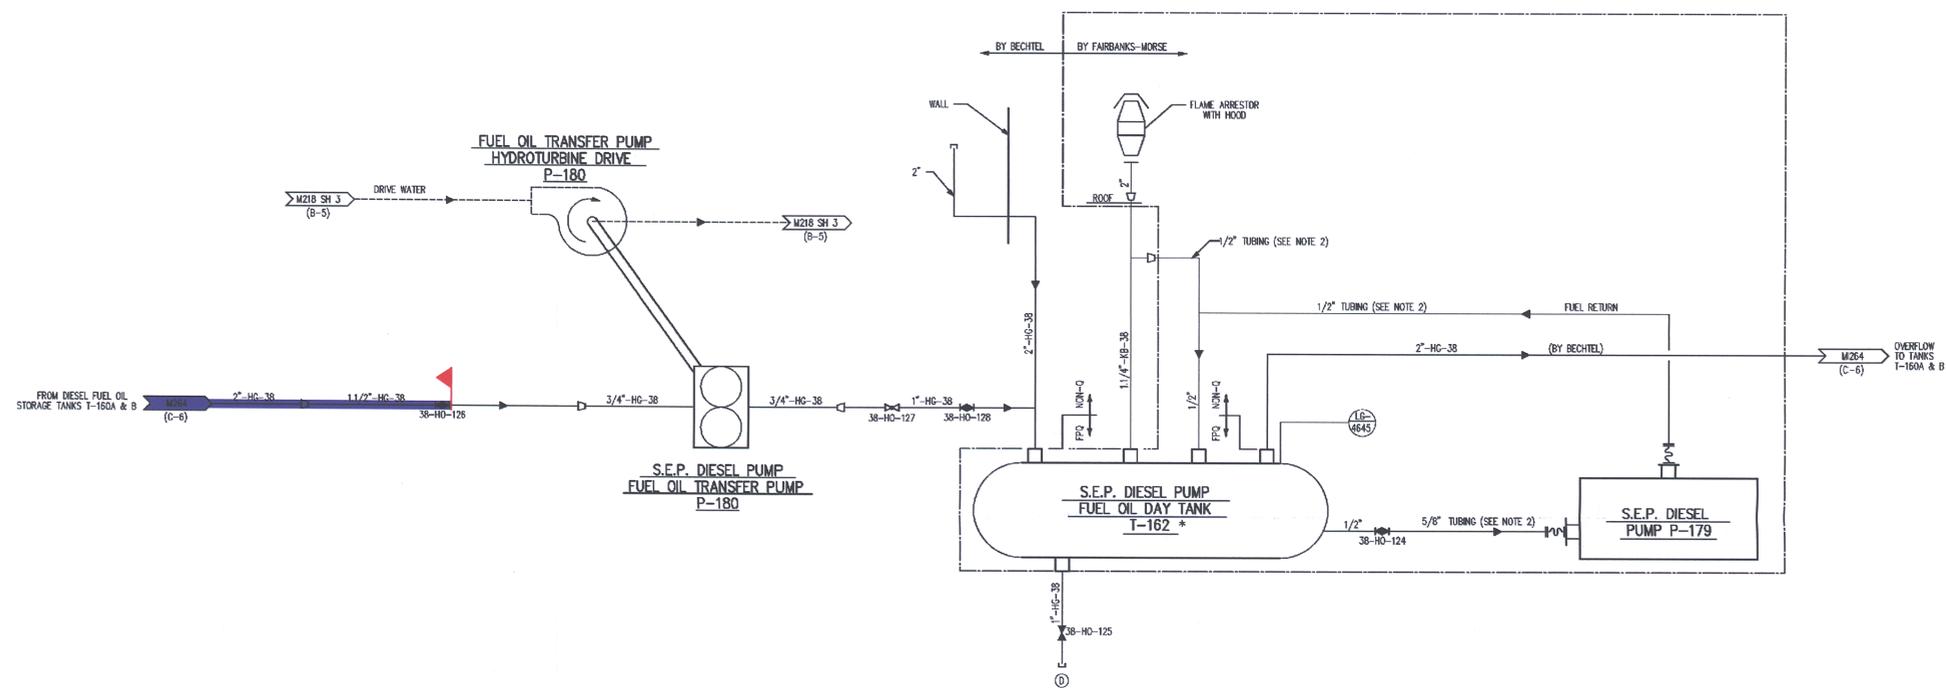

SYSTEM INTENDED FUNCTION BOUNDARY

COMPONENTS SUBJECT TO AMR

FUEL OIL SYSTEM AMRM-15

FORMERLY SKM 86-52C-1

SCALE: NONE		DESIGNED: BECHTEL	DRAWN: J. L. PERLIZZI	E
PILGRIM STATION NO. 600		BOSTON EDISON COMPANY		
TITLE: P & ID SAFETY ENHANCEMENT PROGRAM DIESEL PUMP FUEL OIL TRANSFER SYS.				
DRAWING NO. M265		REV. E3		
BY: [Signature]		CHECKED: [Signature]		
DATE: 10/11/05		PROJECT: 41100-4983		

NO.	DATE	DESCRIPTION	BY	CHK	APP
01	2-9-05				
REVISIONS					
LRA-M-265-0					
DGN FILE: LRA-M-265_E03.DGN					
PLOT FILE: M265-CALS_E03.CAL					