
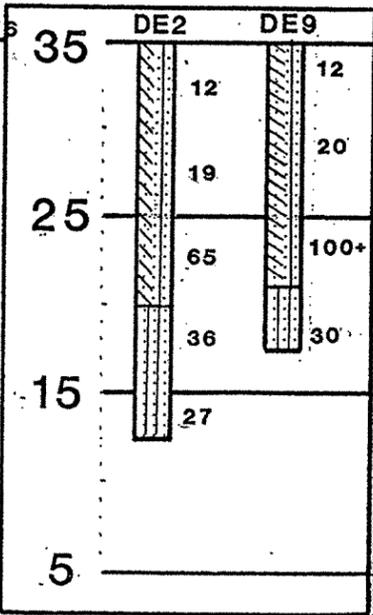
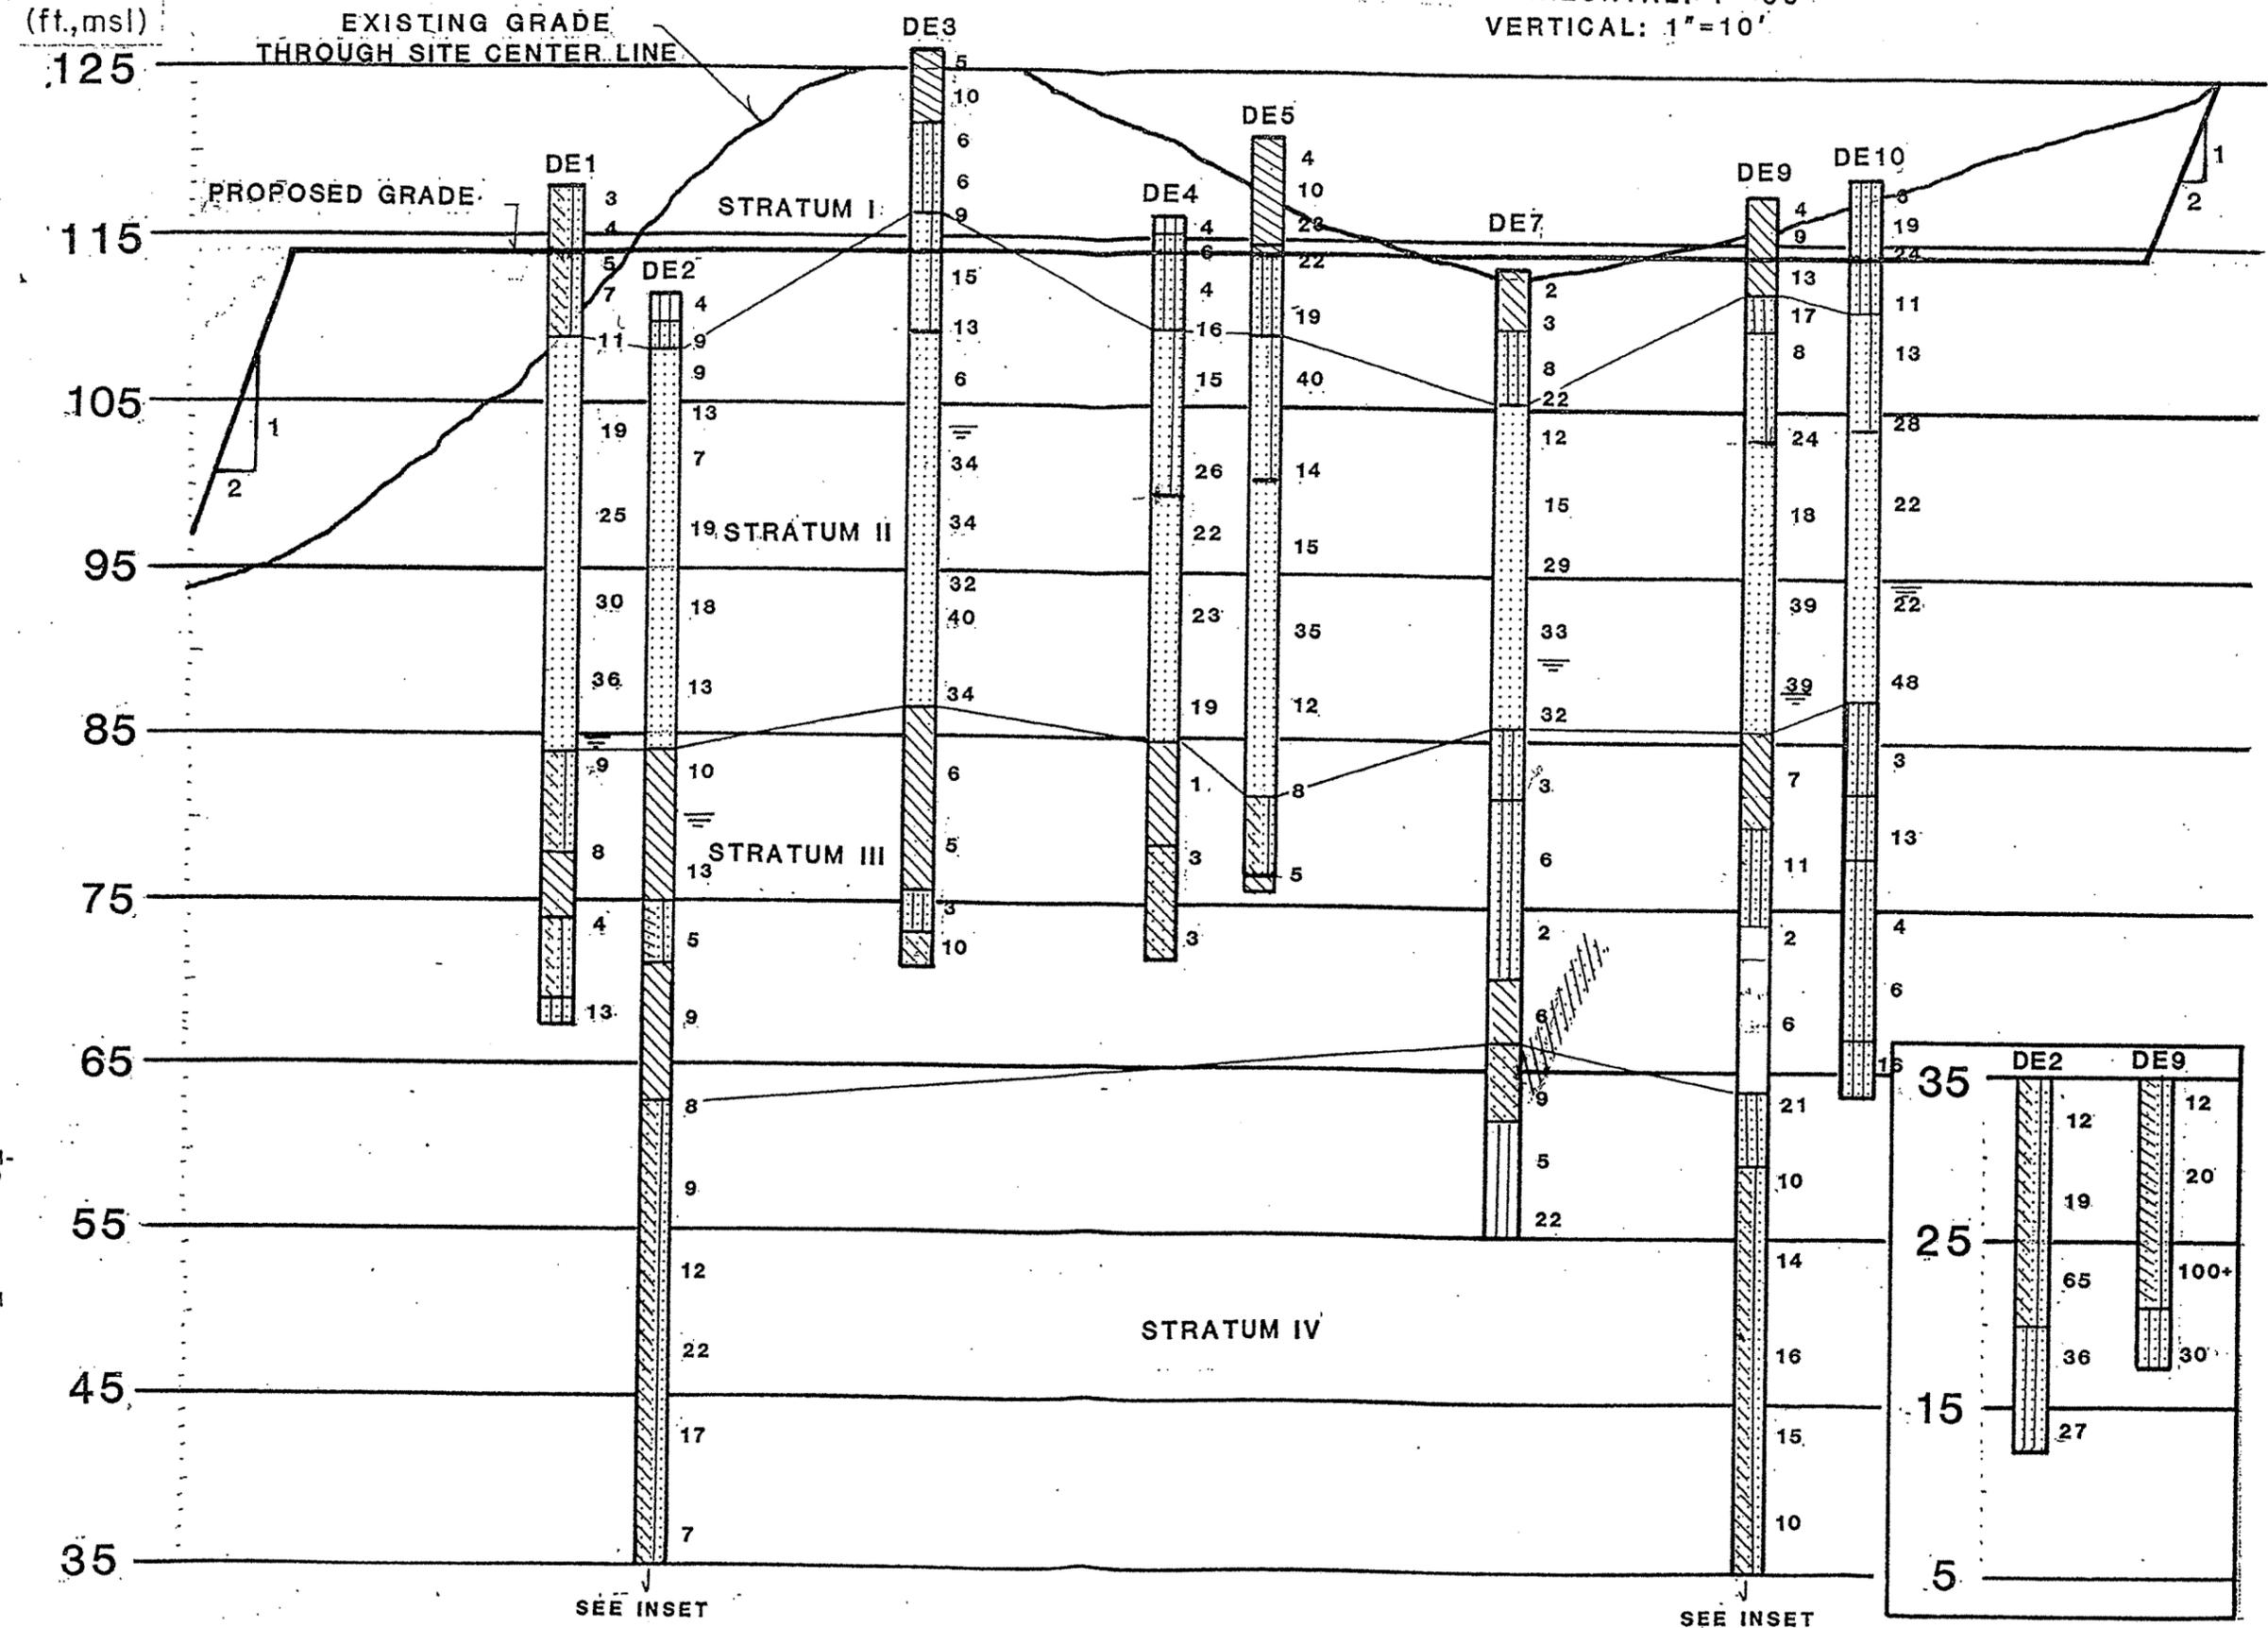


Elevation
(ft.,msl)

SCALE: HORIZONTAL: 1"=60'
VERTICAL: 1"=10'

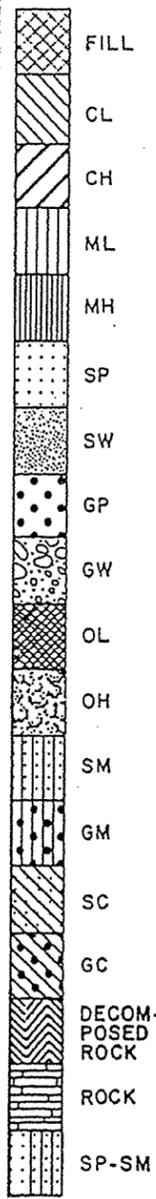

Job No. B8-692
Drawn: JHC
Checked: DDF
Date: 3-6-89

ESTIMATED SUBSURFACE
PROFILE A-A

CALVERT CLIFFS NUCLEAR POWER PLANT
ISFSF
CALVERT COUNTY, MARYLAND

Figure 2.6-7A