


REVISIONS	
0	DRAWN BY: JLB DATE: 3-2-07 PREPARED BY: WJO DATE: 3-2-07 REVIEWED BY: SRM DATE: 3-2-07
1	ENLARGED BOUNDARY FLAGS AND HIGHLIGHTED DRAINS (a)(2).
	DRAWN BY: JLB DATE: 8-29-07 PREPARED BY: WJI DATE: 8-29-07 REVIEWED BY: SRM DATE: 9-14-07

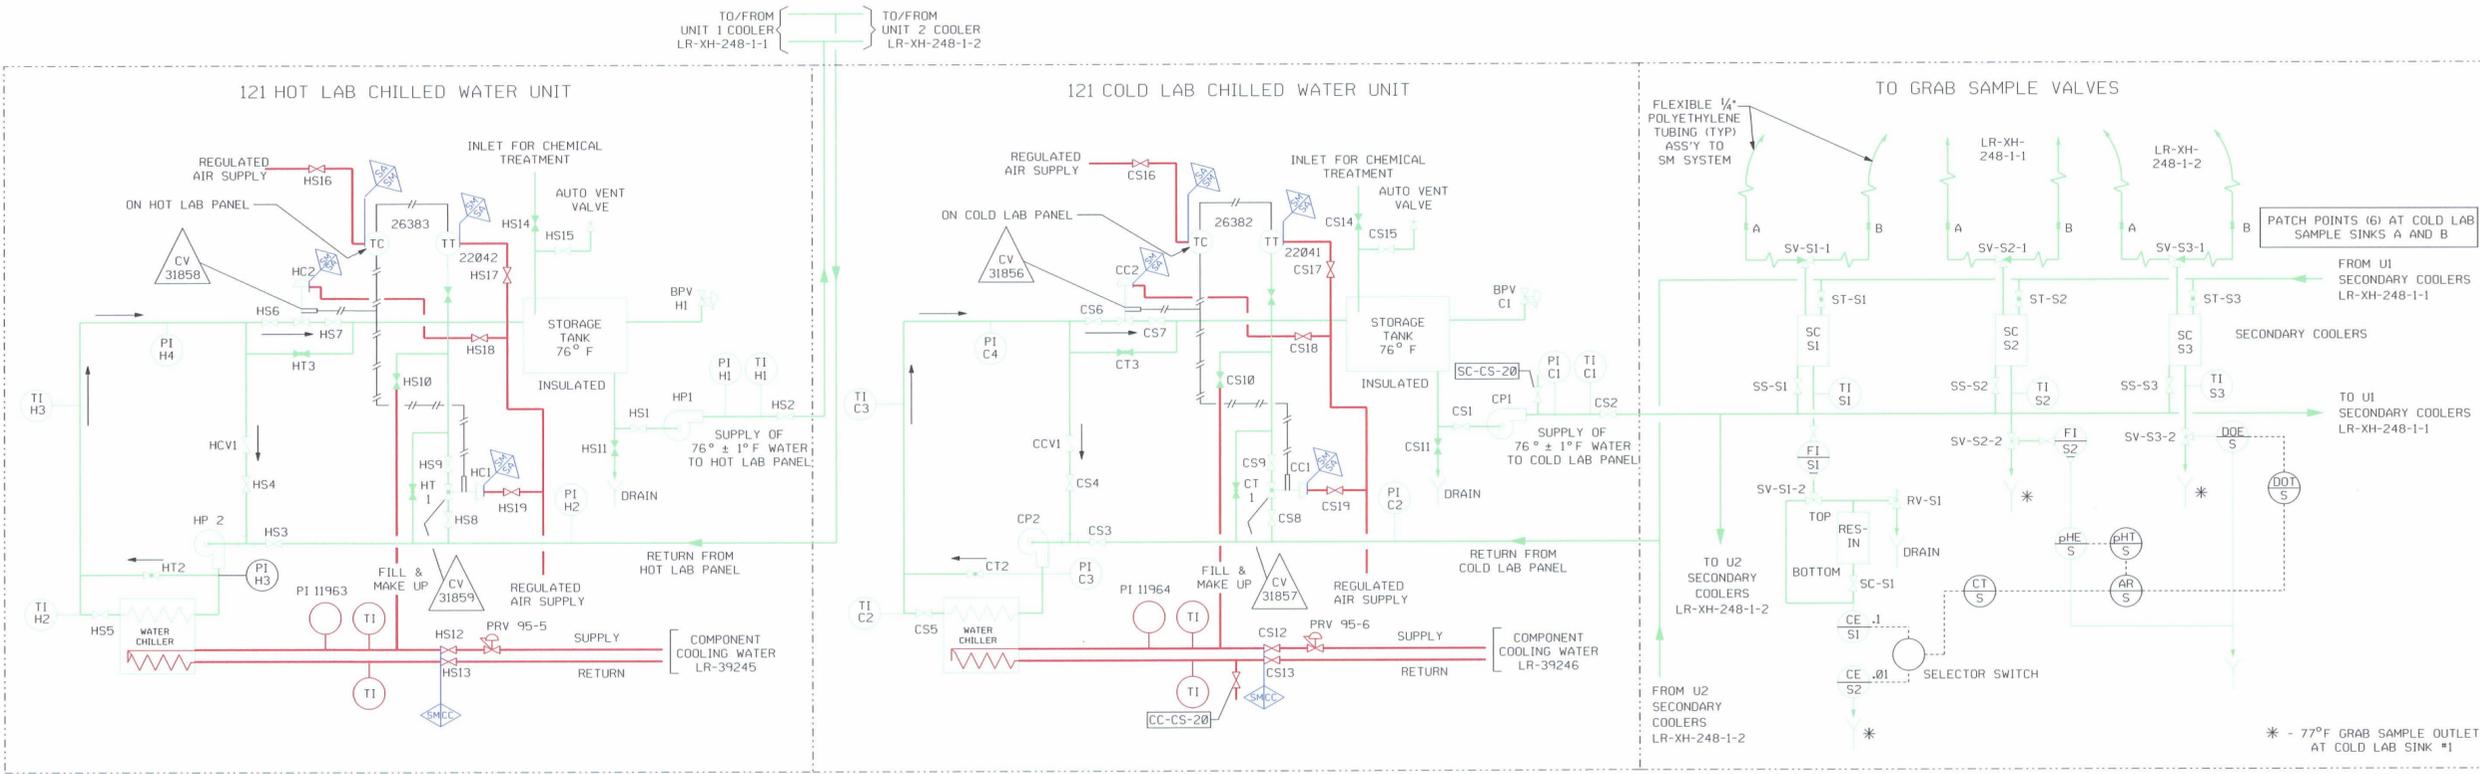

LR - LEGEND	
—	IN SCOPE FOR LR PER 10 CFR 54.4(a)(1) 10 CFR 54.4(a)(3)
—	IN SCOPE FOR LR PER 10 CFR 54.4(a)(2)
—	OUT OF SCOPE
	DENOTES SYSTEM BOUNDARY BREAK

LR - SYSTEMS	
SA	STATION AND INSTRUMENT AIR
SM	PLANT SAMPLE SYSTEM
CC	COMPONENT COOLING

REFERENCE DWG. X-HIAW-248-1-3 REV. C
VENDOR - LEEDS & NORTHRUP CO.
DWG. # X-PID-3700-104

DATE	DESCRIPTION	BY	CHKD	APP'D
06/30				
08/28				
08/28				

I HEREBY CERTIFY THAT THIS PLAN, SPECIFICATION OR REPORT WAS PREPARED BY ME OR UNDER MY DIRECT SUPERVISION AND THAT I AM A DULY REGISTERED PROFESSIONAL ENGINEER UNDER THE LAWS OF THE STATE OF MINNESOTA.
 DATE: _____ REG. NO.: _____

LICENSE RENEWAL BOUNDARY DWG
 P & ID - SAMPLE SYSTEM
 CHILLED WATER UNITS
 LR-XH-248-1-3

11-132