


SEE SHEET CS8103

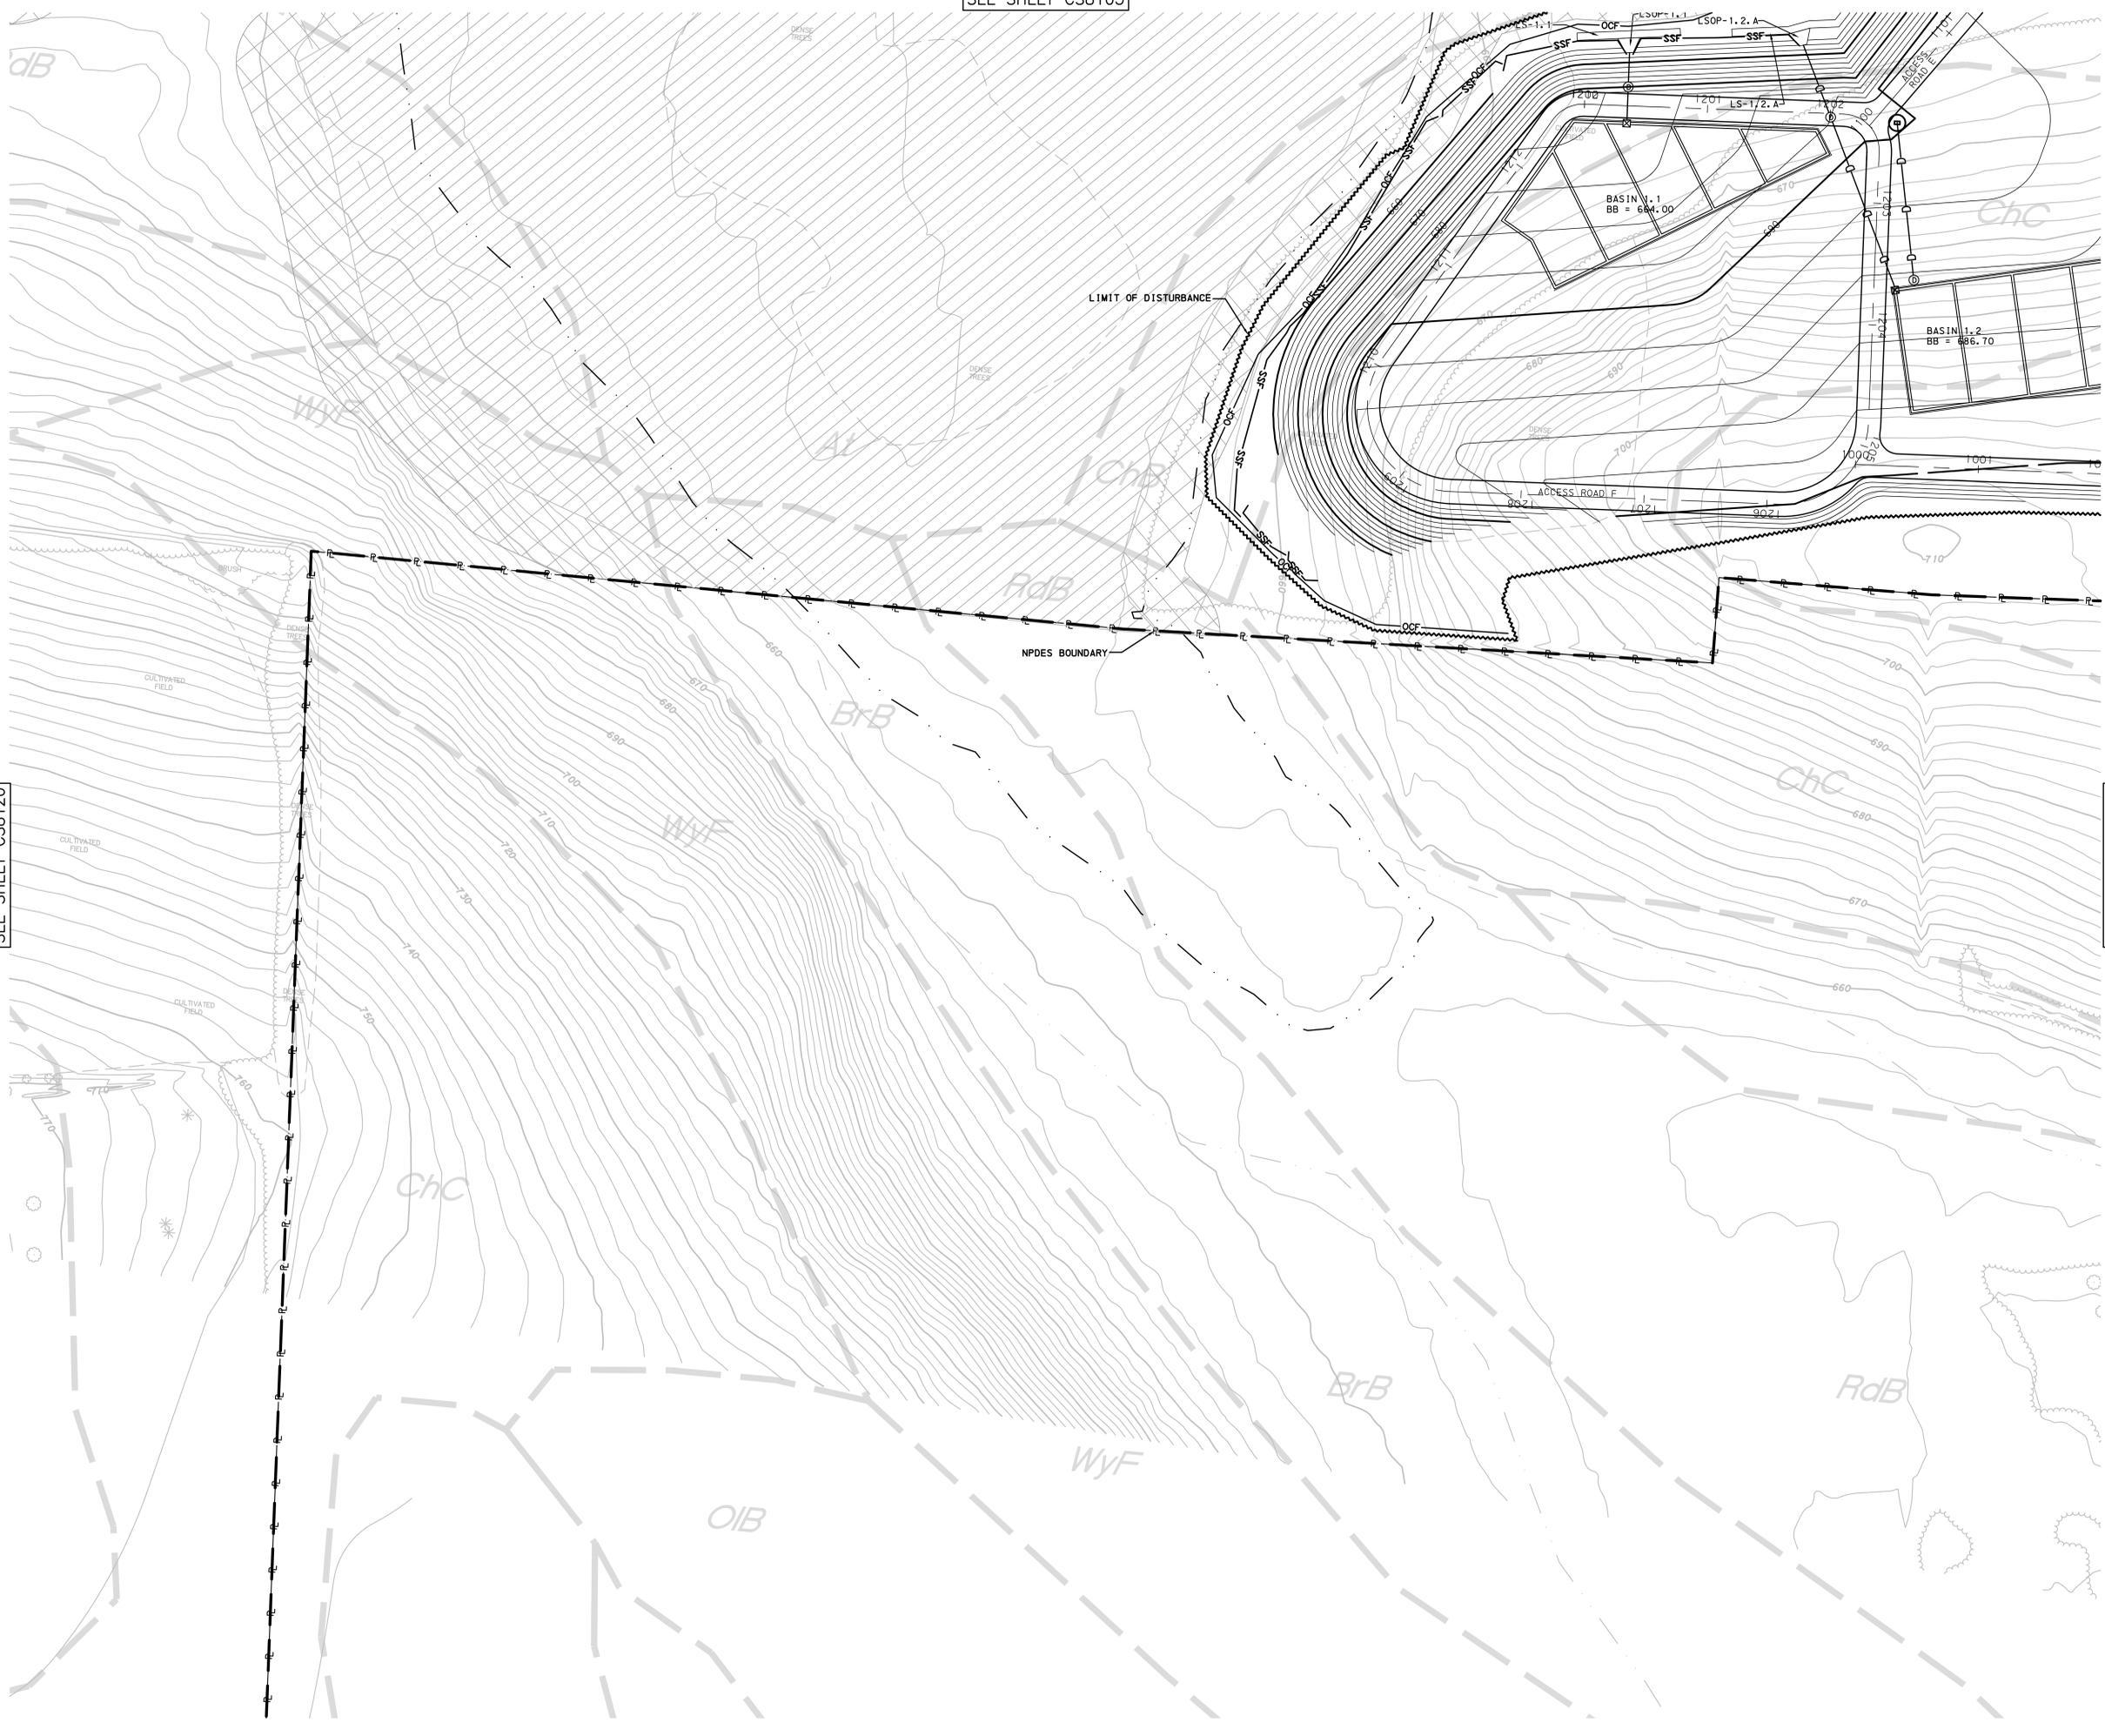

SEE SHEET CS8120

SEE SHEET CS8107



Pennoni Associates Inc.

100 N. Wilkes-Barre Boulevard  
Wilkes-Barre, PA 18702 (570) 824-2200


Engineers • Surveyors • Planners • Landscape Architects

SCALE	1"=50'
DRAWN BY	MLF
DATE	9/15/2011
APPROVED	JFM
DRAWING NO.	<b>CS 8121A</b>

JOB NO.	PPLS0902
SHEET	36 OF 75

ALL DOCUMENTS PREPARED BY PENNONI ASSOCIATES ARE INSTRUMENTED BY EXEMPT IN RESPECT OF THE PROJECT. THEY ARE NOT INTENDED OR REPRESENTED TO BE SUITABLE FOR REUSE BY OWNER OR OTHERS ON EXTENSIONS OF THE PROJECT OR ON ANY OTHER PROJECT. ANY REUSE WITHOUT WRITTEN APPROVAL OR PERMISSION BY PENNONI ASSOCIATES FOR THE SPECIFIC PURPOSE INTENDED WILL BE AT OWNER'S SOLE RISK AND WITHOUT LIABILITY OR LEGAL EXPOSURE TO PENNONI ASSOCIATES. AND OWNER SHALL INDEMNIFY AND HOLD HARMLESS PENNONI ASSOCIATES FROM ALL CLAIMS, DAMAGES, LOSSES AND EXPENSES ARISING OUT OF OR RESULTING THEREFROM.

**BELL BEND NUCLEAR POWER PLANT**  
**EROSION AND SEDIMENTATION CONTROL PLANS**  
**PERMANENT FEATURES**  
**PPL BELL BEND, LLC**  
 38 BOMBAY LANE, SUITE 2  
 BERWICK, PA 18603

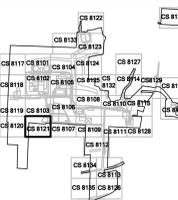

ALL DIMENSIONS MUST BE VERIFIED BY CONTRACTOR ASSUMES RESPONSIBILITY FOR VERIFYING DIMENSIONS BEFORE PROCEEDING WITH THE WORK.

DATE	NO.	REVISIONS	BY
9/15/11	1	EXCESS EARTHWORK REDUCTION AND L&D COMMENTS	DFC
11/12/10	0	INITIAL SUBMISSION	DFC



\\PENNONI\PROJECTS\WILKES-BARRE\Bell Bend Land Development\DESIGN\CS8121A.dwg  
 9/15/11 10:58 AM  
 JFM