

REVISIONS				
NO	DATE	DESCRIPTION	BY	CH
10	5-20-87	THIS DRAWING HAS BEEN PHOTOGRAPHICALLY REPRODUCED FOR PREVIOUS REVISIONS SEE RECORD DRAWING 2998-G-064 REV. 9 PCM 406-283; ADDED: (G-9, H-8, K-5, L-8 TO L-10) PLATFORMS	NA	HK
11	9-17-87	APPR'D BY H.H. CHEN FL PE #45018 PCM 120-290 REV: (D-1) DIM; GELL DEL: (H-18) DWG LIST REF	DP	DNC
12	4-26-94	PCM 064-243 REV: (M3-4) SECT D-D	NA	FB
13	12/8/95	PCM 052-295; DEL: (L-5) VACUUM DEGAS.	WJ	PDB
14	5-1-96	PCM 051-295; ADDED: (L-5) TURBINE LUBE OIL MIST ELIMINATOR & PLATFORM	HS	GW
15	11-13-96	PCM 35032; ADD: (H3-4, H7-8, L8) EQUIP. & TAG NOS.	PDB	AM
16	8/11/03	PCM 05055; ADD: (L-6) SMART-VAC	AM	GW
17	3/5/08	PCM 05118; REV: (M2-M3, M5-M6) CURB.	GW	AM

LEGEND


- FIRE HOSE STATION
- DRY CHEMICAL EXTINGUISHER
- CO2 FIRE EXTINGUISHER
- IONIZATION DETECTOR

GENERAL NOTES




1. PLANT DATUM SHALL BE MEAN LOW WATER IN ATLANTIC OCEAN EL. 0.00'

REFERENCE DRAWINGS

SITE PLAN	2998-G-058
ENLARGED PLOT PLAN	2998-G-059
G A TURB BLDG GRD FL	2998-G-060
G A TURB BLDG MEZZ FL	2998-G-061
G A TURB BLDG OPER FL	2998-G-062
G A TURB BLDG SECTS SH 1	2998-G-063
G A RCB SECTS SH 2	2998-G-068
G A RAB PLAN SH 1	2998-G-069
G A FHB PLANS	2998-G-073

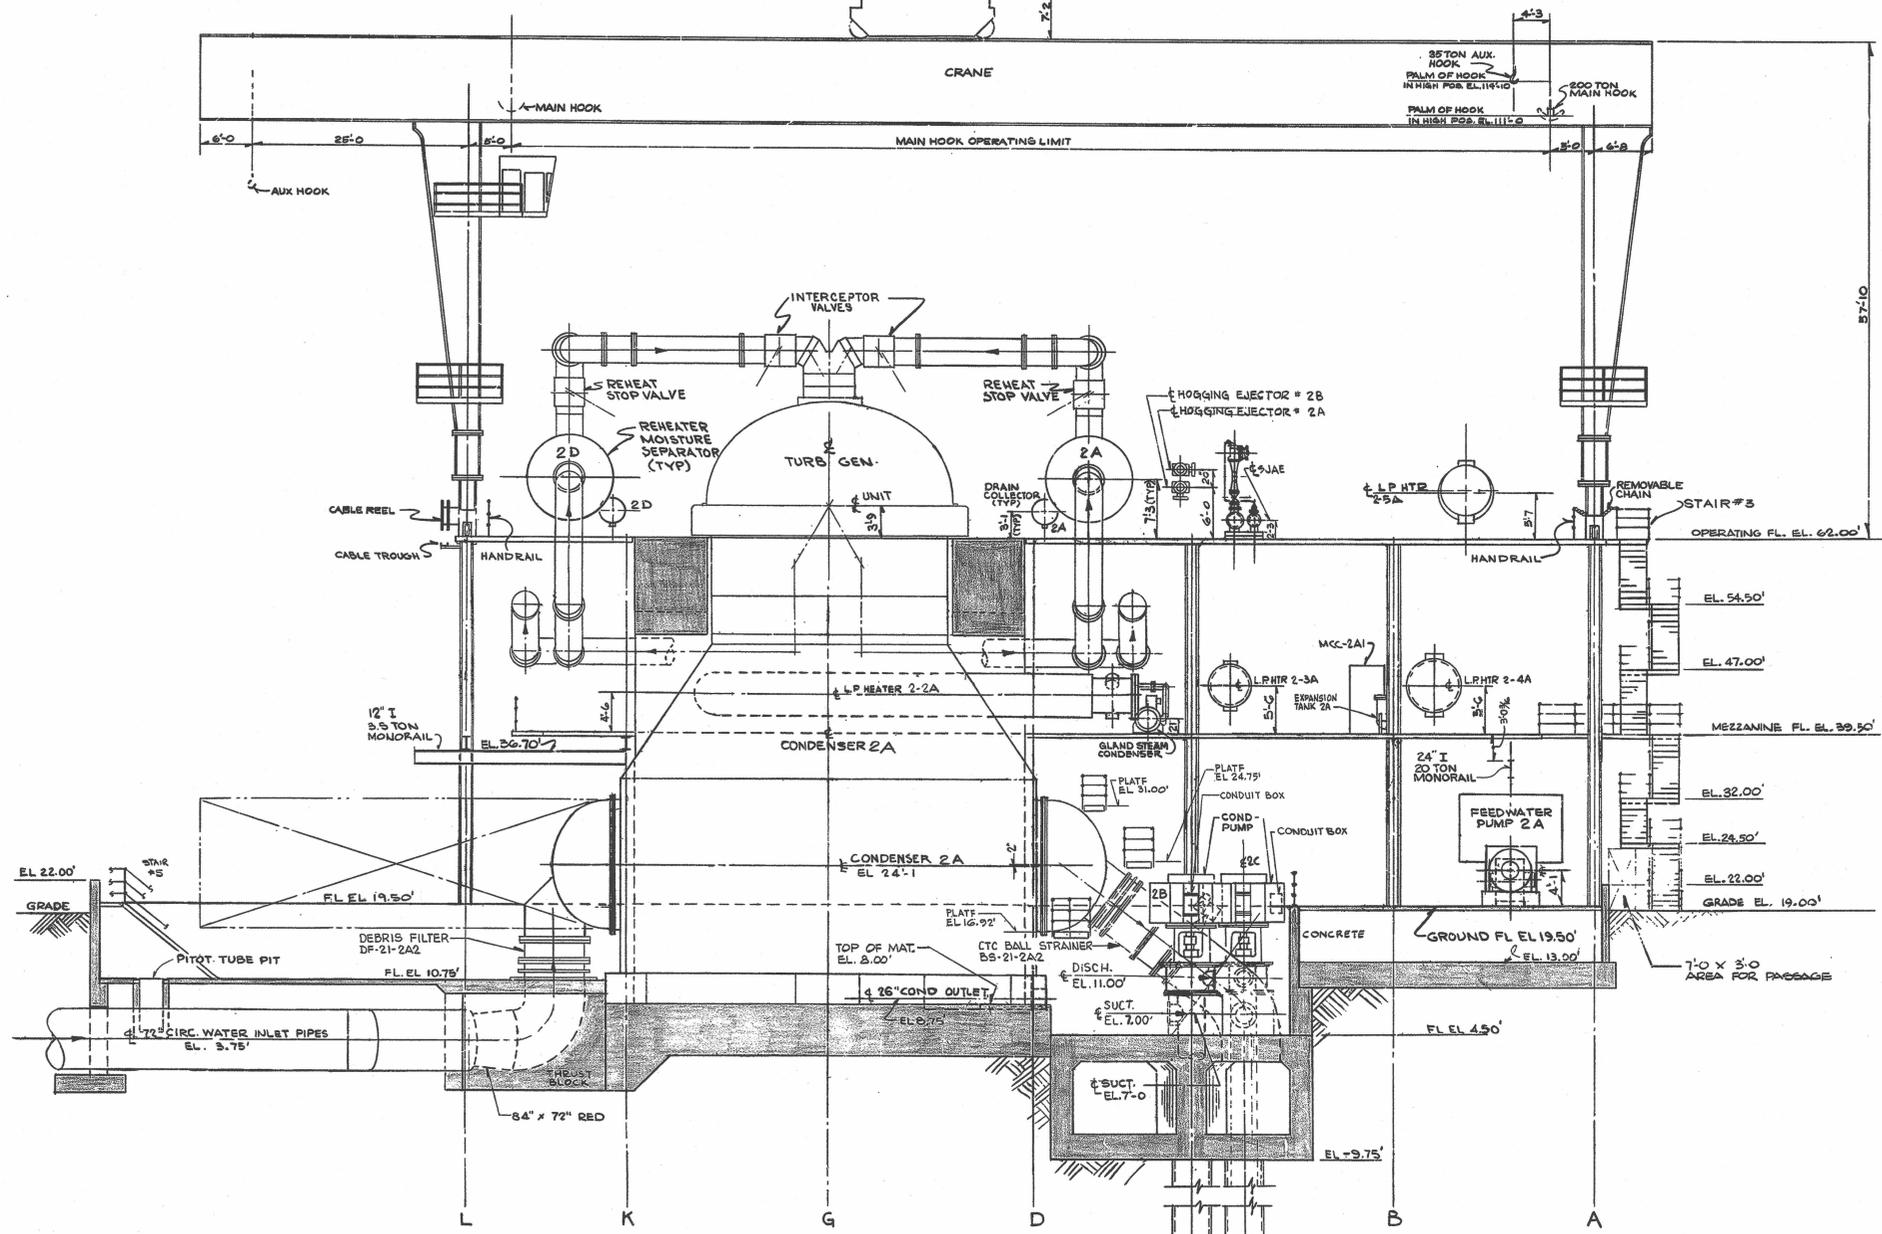

 SECTION C-C
 2998-G-060 (M-10)
 2998-G-061 (L-9)
 2998-G-062 (M-10)

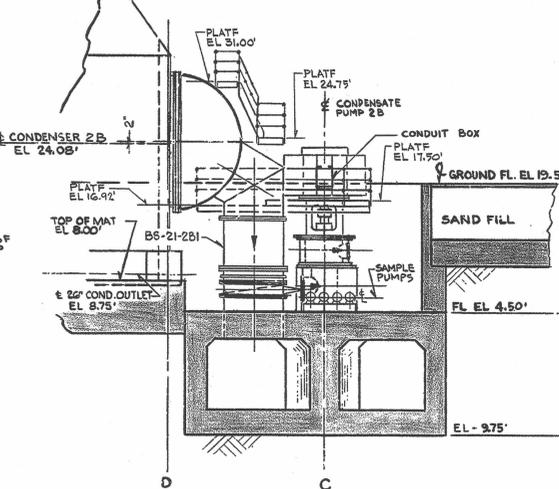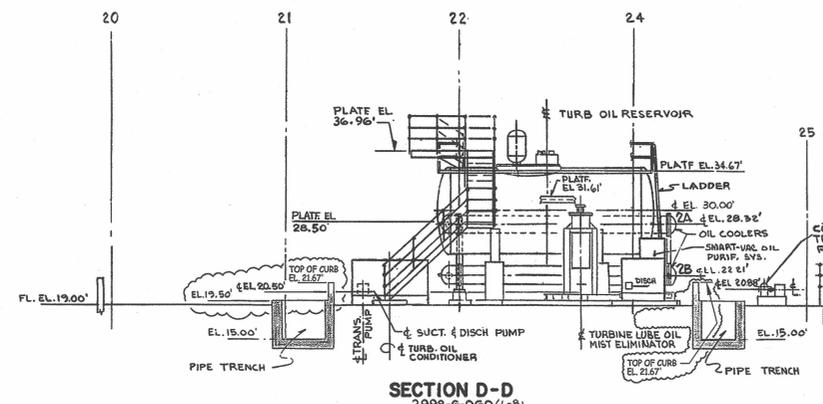

THE DESIGN INFORMATION FOR THE CHANGES SHOWN IN THIS REVISION HAS BEEN ENGINEERED BY FLORIDA POWER & LIGHT COMPANY.

THIS DOCUMENT IS THE PROPERTY OF EBASCO SERVICES INCORPORATED. ITS USE IS EXPRESSLY RESTRICTED BY THE TERMS OF THE CONTRACT, DATED 28 OF SEPTEMBER 1, 1975 BETWEEN EBASCO SERVICES INCORPORATED AND FLORIDA POWER & LIGHT COMPANY.

FLORIDA POWER & LIGHT COMPANY
 ST. LUCIE PLANT
 1983-890 MWe EXTENSION UNIT # 2
 GENERAL ARRANGEMENT
 TURBINE BUILDING-SECTIONS-SHEET 2

EBASCO SERVICES INCORPORATED

SCALE 1/8"=1'-0" APPROVED DATE MAY 26, 1987
 DIV. MECH. DR. AMOROS 2998-
 CH. KRZEPKOWSKI G-064 17