
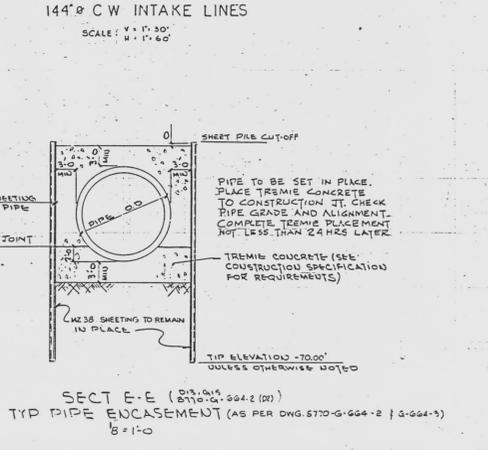
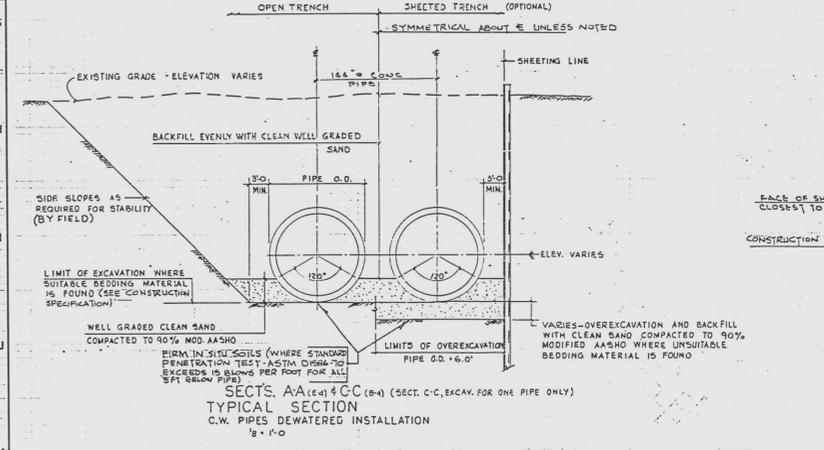


DRAWING NUMBER 8770-G-664
 DRAWING NUMBER 8770-G-664
 DRAWING NUMBER 8770-G-664

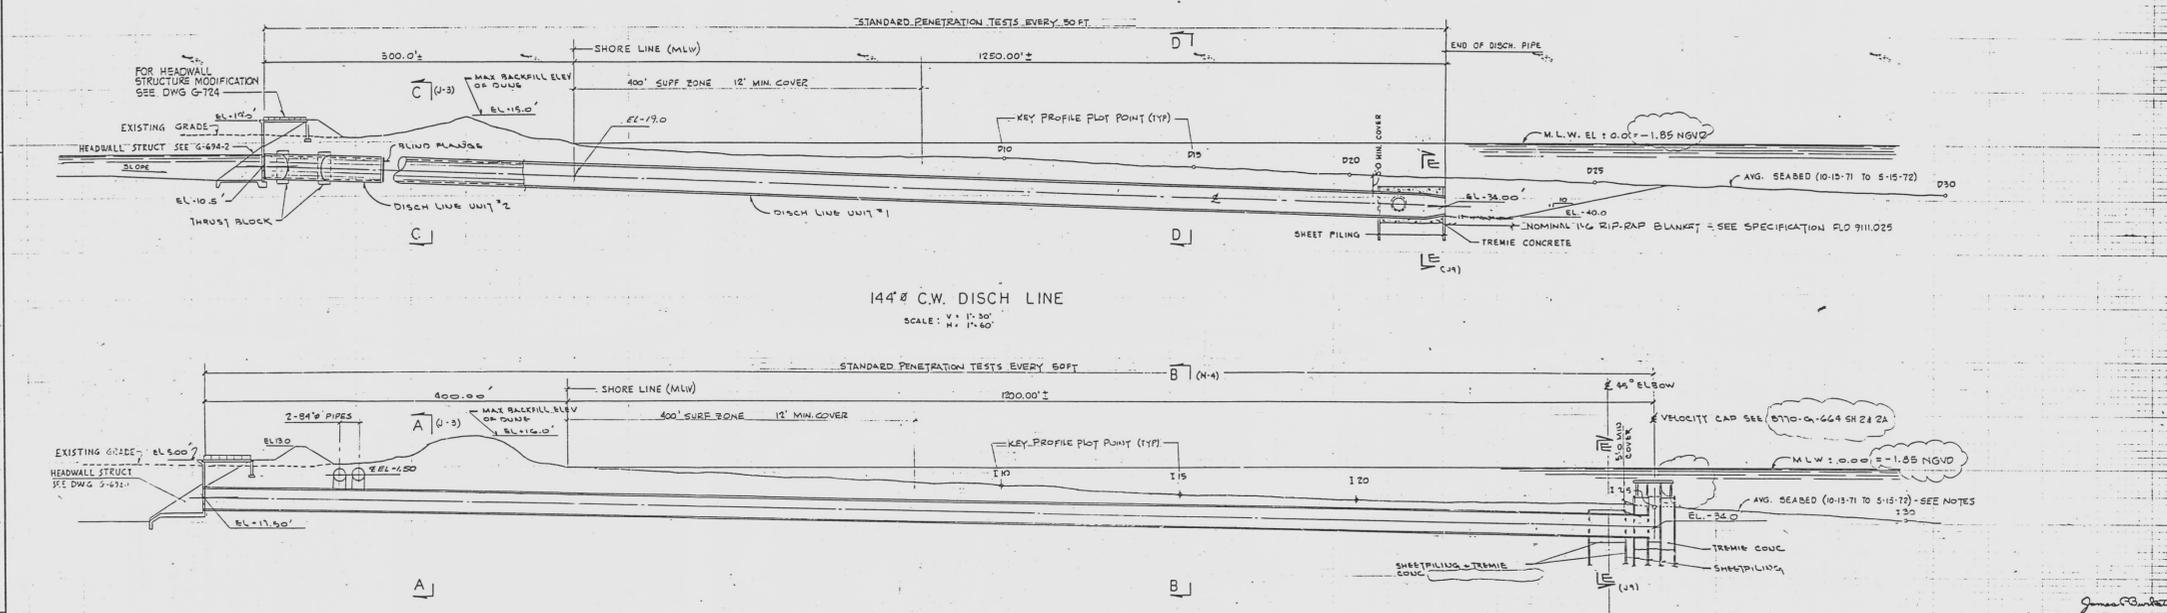

NOTES
 THE BOTTOM PROFILES SHOWN ARE AN AVERAGE ONE & MONTHLY PROFILES TAKEN BETWEEN OCT. 71 & MAY 72. INDIVIDUAL MONTHLY PROFILES ARE AVAILABLE AT SITE. THE PLOT SHOWN MAY NOT REPRESENT THE ACTUAL OCEAN BOTTOM ENCOUNTERED DURING CONSTRUCTION. END CENTERLINE ELEVATION OF PIPE MUST BE MEASURED AT A STRAIGHT GRADE BETWEEN SPECIFIC ELEVATIONS.
 ALL ELEVATIONS ARE REFERENCED TO MEAN LOW WATER (MLW) ELEV. 0.00

REFERENCE DRAWINGS
 LIST OF DRAWINGS 8770-A-145
 C.W. OCEAN INTAKE & DISCHARGE "PLAN" 8770-G-664-50
 HEADWALL STRUCT'S SECT'S & DETAILS 8770-G-664-1
 HEADWALL STRUCT'S SECT'S & DETAILS 8770-G-664-2
 C.W. OCEAN INTAKE & DISCH. SECT'S (DETS) 8770-G-664-3
 C.W. OCEAN INTAKE & DISCH. SECT'S (DETS) 8770-G-664-4
 C.W. VELOCITY CAP REPAIR PLAN & SECT 8770-G-664-51

**AS BUILT DRAWING
 TRANSFERRED TO FPL**

NO.	DATE	REVISION	BY	CHK.	APPROVED
5	2/16/73	REV. (E-1) TO E-10) SEE DWG. 8770-G-664-50	JK	JK	JPE
4	3-21-68	REV. (E-1) TO E-10) SEE DWG. 8770-G-664-50	JK	JK	JPE
3	11-1-67	REV. (E-1) TO E-10) SEE DWG. 8770-G-664-50	JK	JK	JPE
2	1-3-72	REV. (E-1) TO E-10) SEE DWG. 8770-G-664-50	JK	JK	JPE
1	7-26-72	REV. (E-1) TO E-10) SEE DWG. 8770-G-664-50	JK	JK	JPE

FLORIDA POWER & LIGHT CO.
JPE
 POWER PLANT ENGINEERING

FLORIDA POWER & LIGHT COMPANY
 HUTCHINSON ISLAND PLANT
 1973 - 890,000 KW INSTALLATION - UNIT NO. 1
CIRCULATING WATER SYSTEM
 OCEAN INTAKE & DISCHARGE "PROFILE"

ESBSCO SERVICES INCORPORATED NEW YORK
 APPROVED DATE 12-1-72
 8770-G-664